


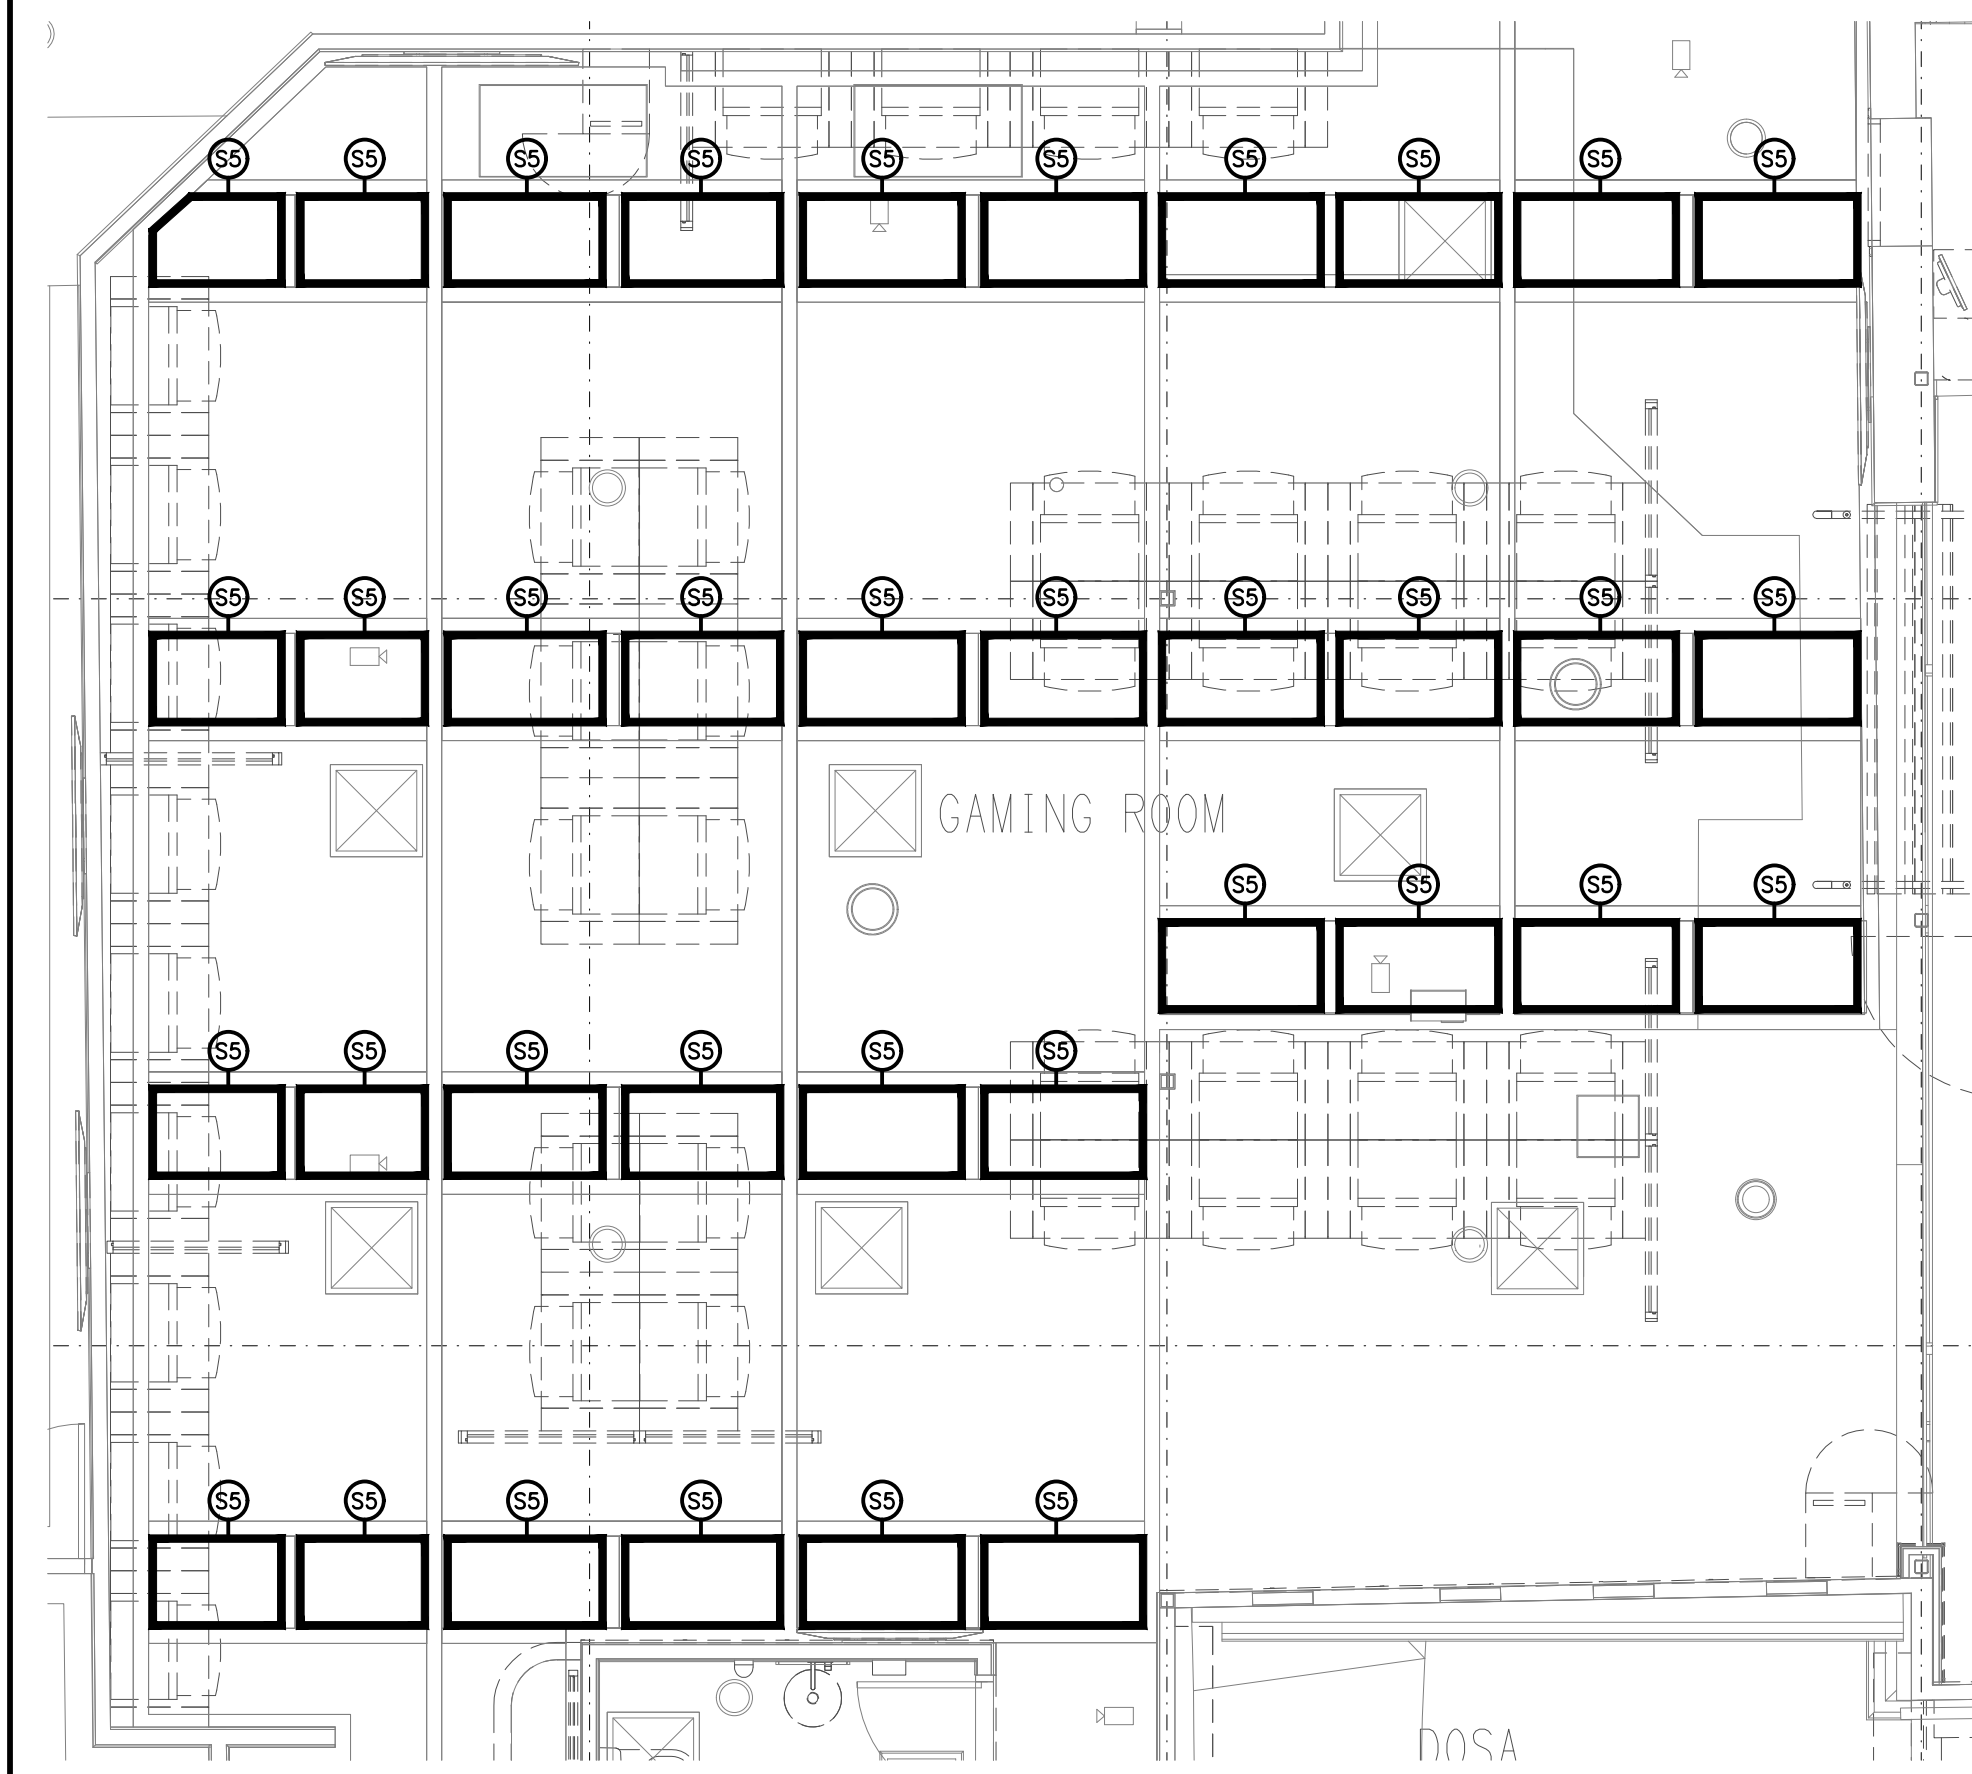

DETAIL A
GAMING ROOM S5 FEATURE LIGHTING PLAN
SCALE 1:50

NOTE:
REFER TO DRAWING C3685a-E05.dwg FOR THE
ADDITIONAL JOINERY & WALL LIGHTING PLAN

**EXISTING ELECTRICAL SERVICES
WITHIN THIS DASH LINED AREA TO BE
REMOVED, UNLESS NOTED OTHERWISE.**

**REMOVE THE EXISTING FESTOON
LIGHTS IN THIS AREA AND REPLACE
WITH THE NEW FS01. RESUPPLY
ALL EXISTING REMAINING LIGHTS IN
THIS AREA FROM CIRCUIT DB-B-L??
CHANNEL ??**

NOTE:
RESUPPLY THE 4
F01 FANS FROM
CIRCUIT DB-B-L??