


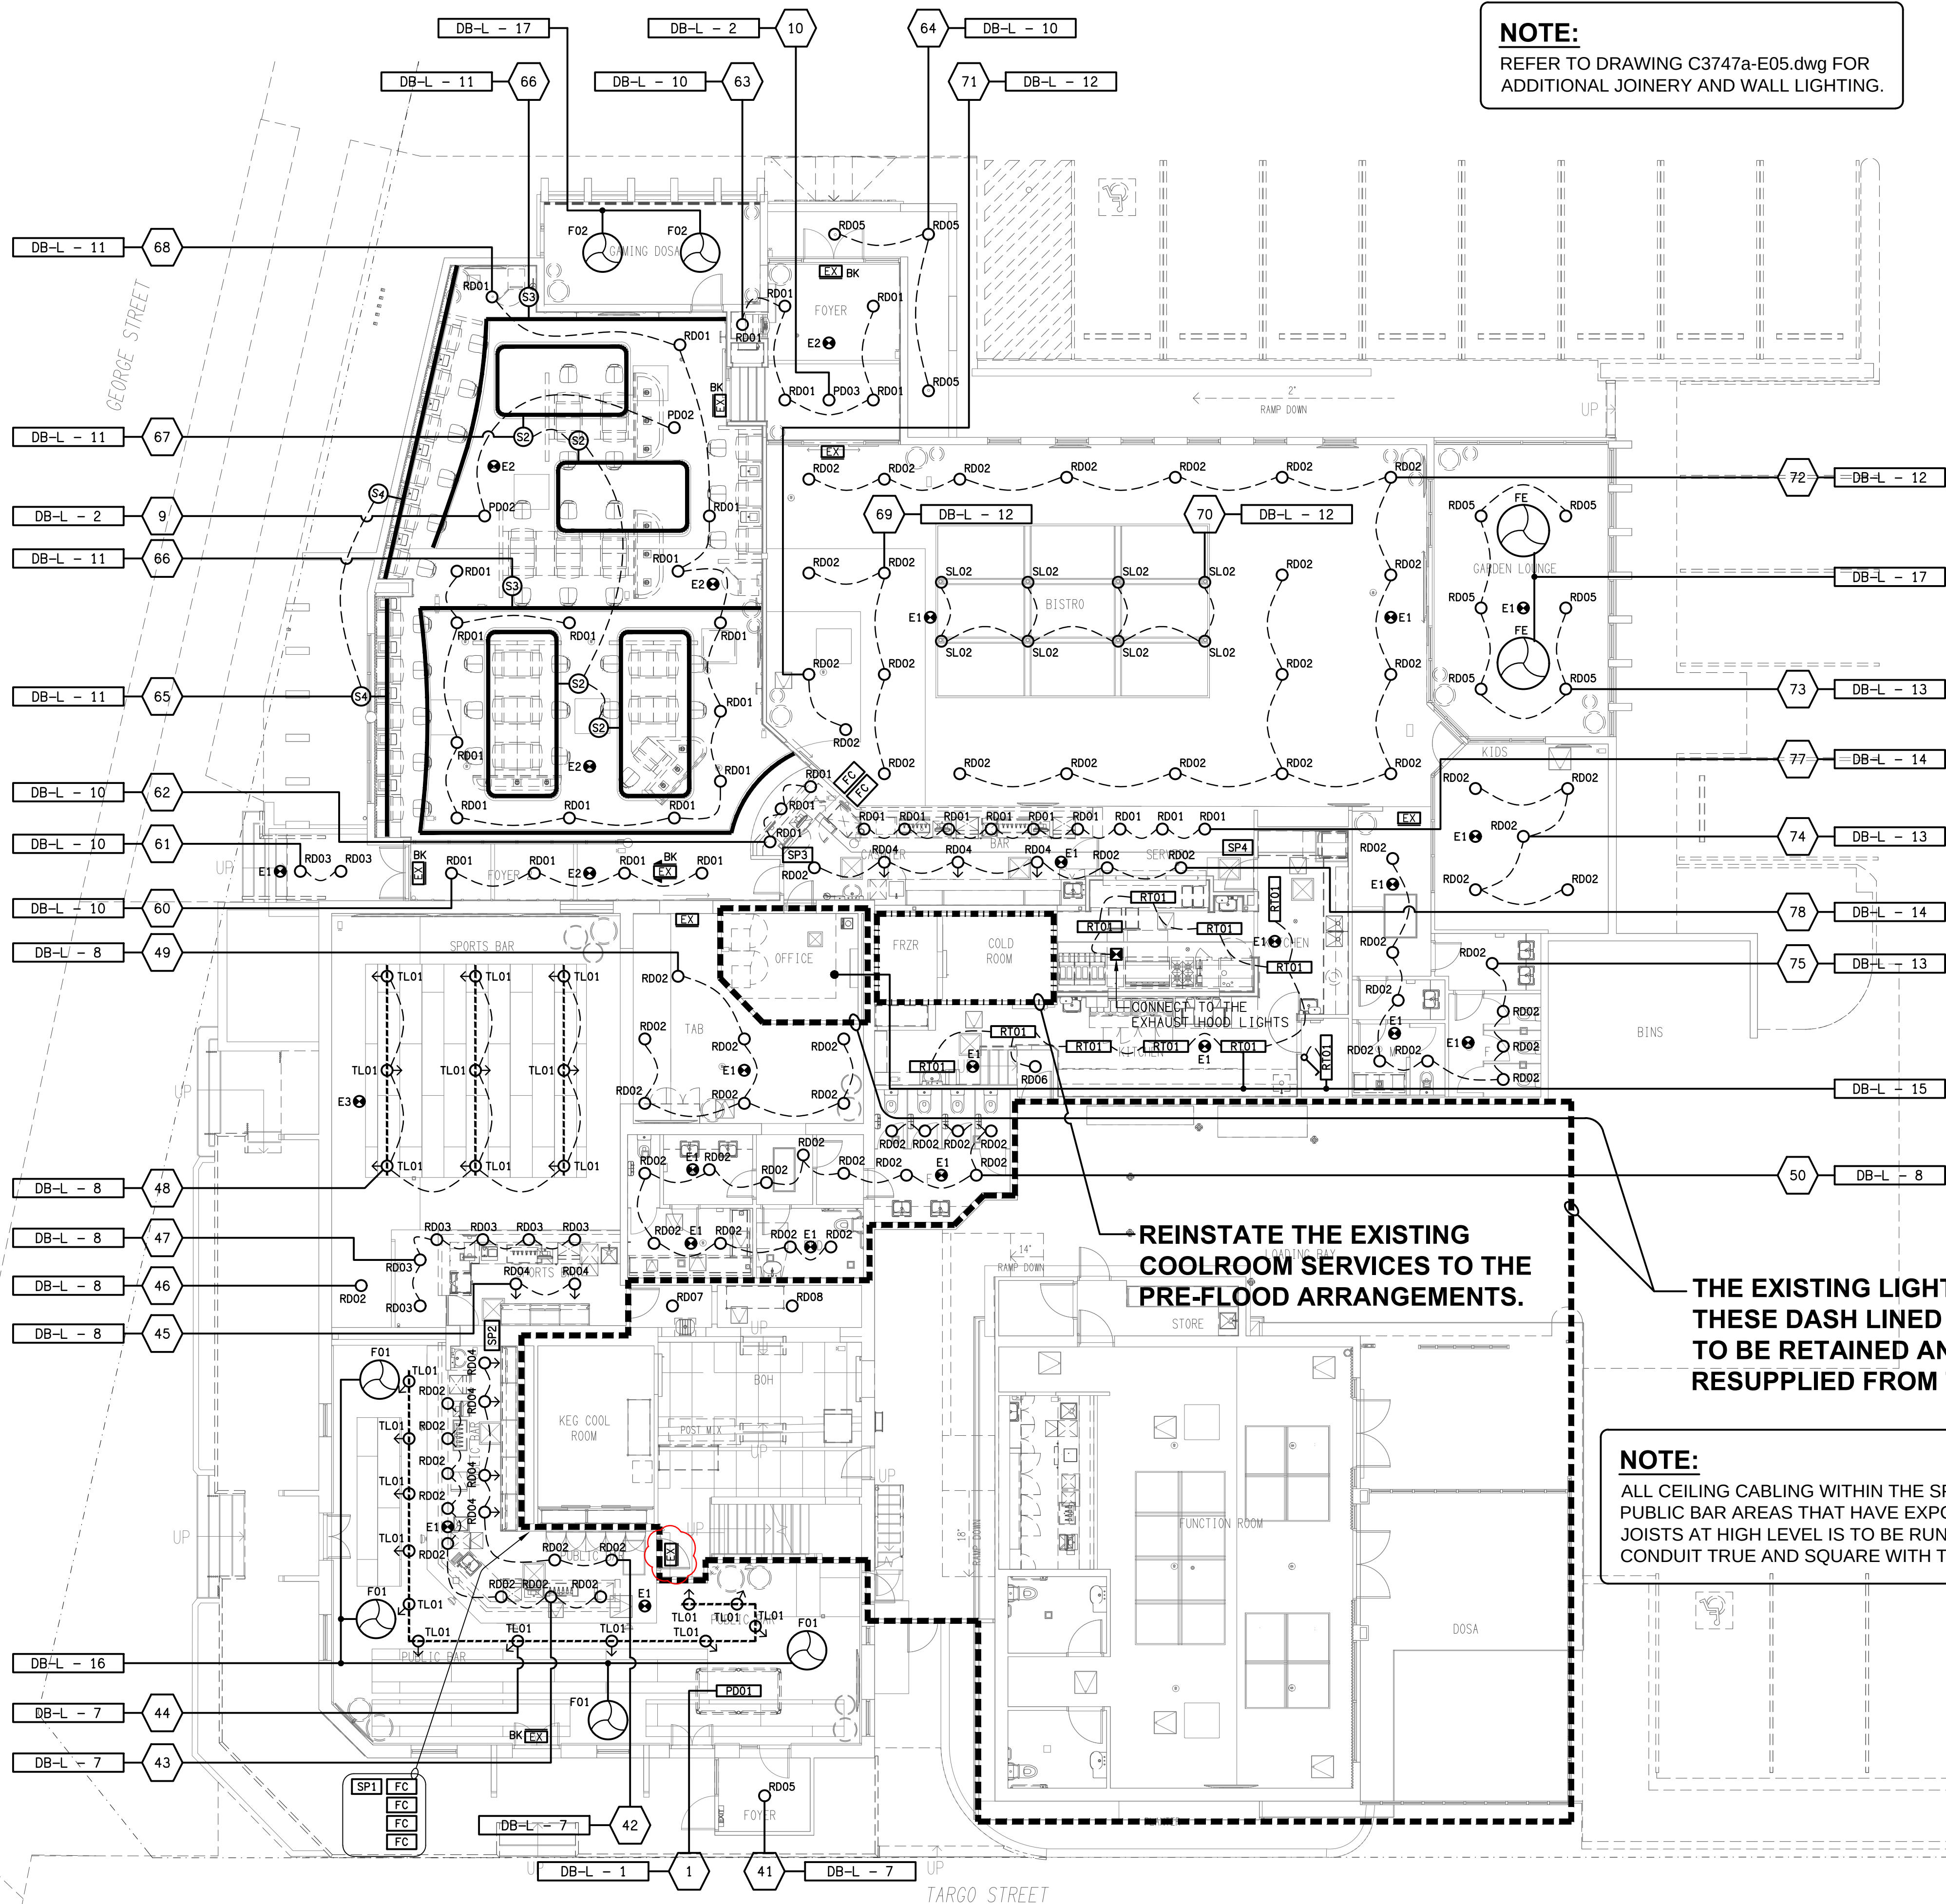


NOTE:
REFER TO DRAWING C3747a-E05.dwg FOR
ADDITIONAL JOINERY AND WALL LIGHTING.

REINSTATE THE EXISTING
COOLROOM SERVICES TO THE
PRE-FLOOD ARRANGEMENTS.

THE EXISTING LIGHTING WITHIN
THESE DASH LINED AREAS ARE
TO BE RETAINED AND
RESUPPLIED FROM THE NEW DB-L

NOTE:
ALL CEILING CABLING WITHIN THE SPORTS BAR AND
PUBLIC BAR AREAS THAT HAVE EXPOSED TIMBER
JOISTS AT HIGH LEVEL IS TO BE RUN IN BLACK
CONDUIT TRUE AND SQUARE WITH THE JOISTS.

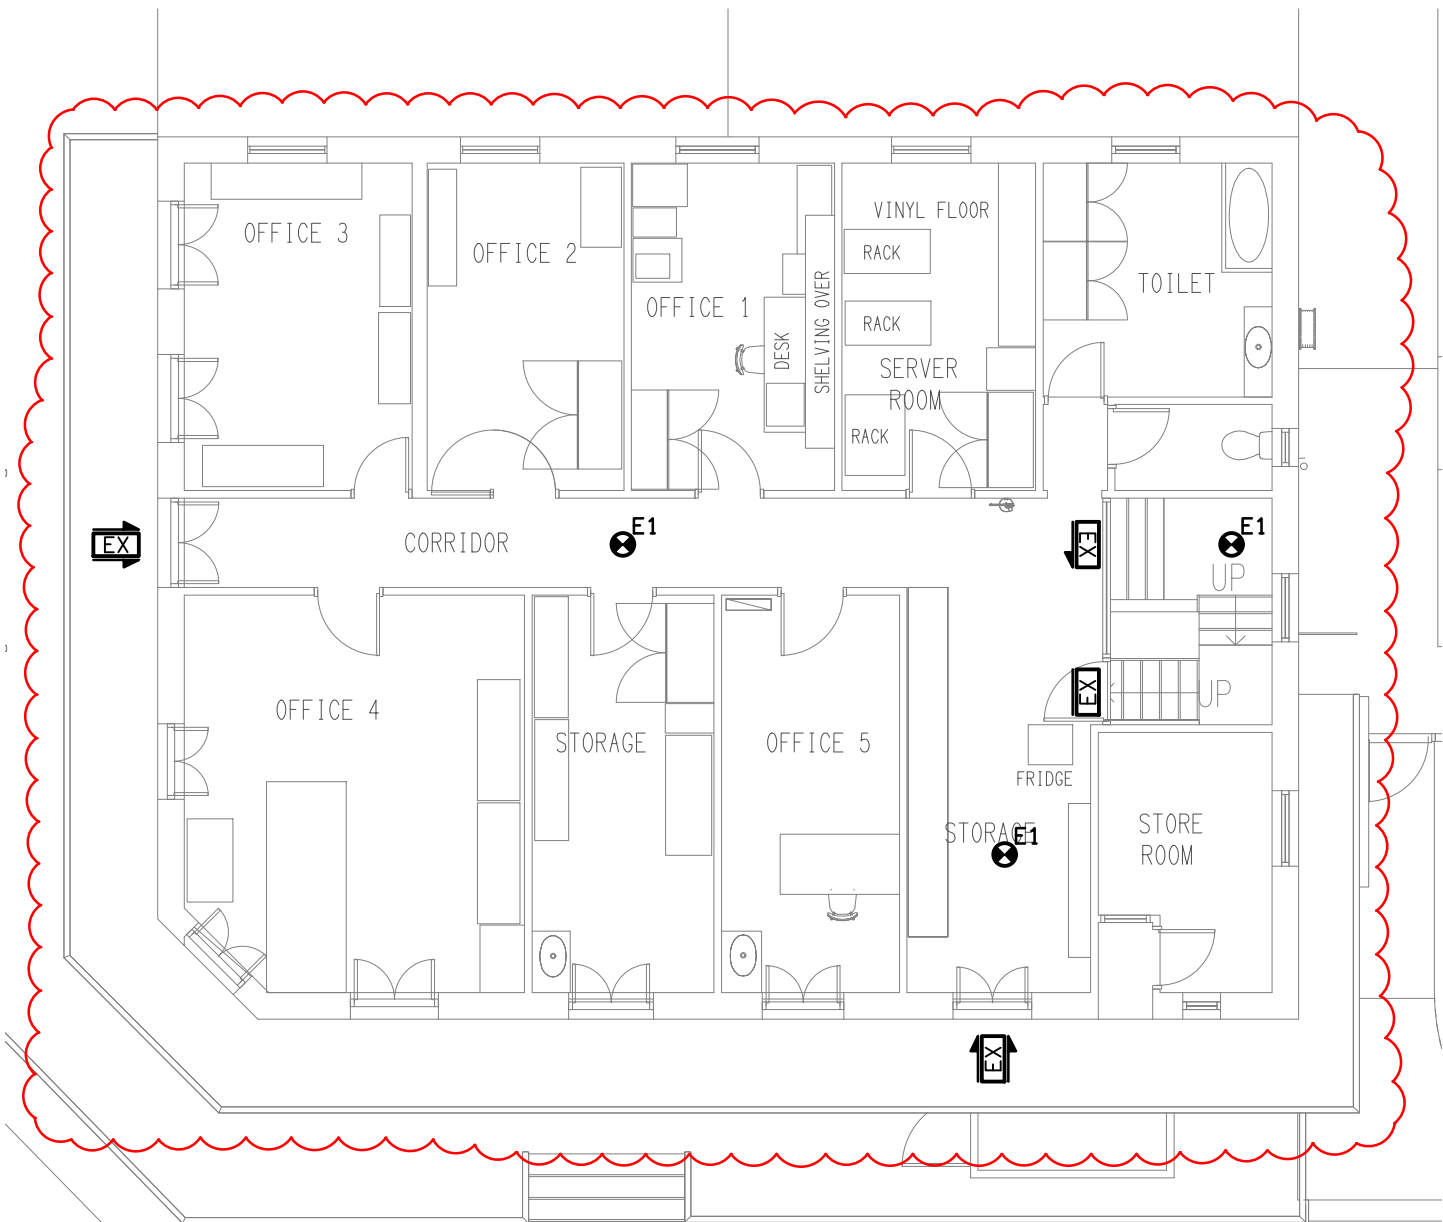

LEVEL 1
EMERGENCY & EXIT LIGHTING PLAN
SCALE 1:100