

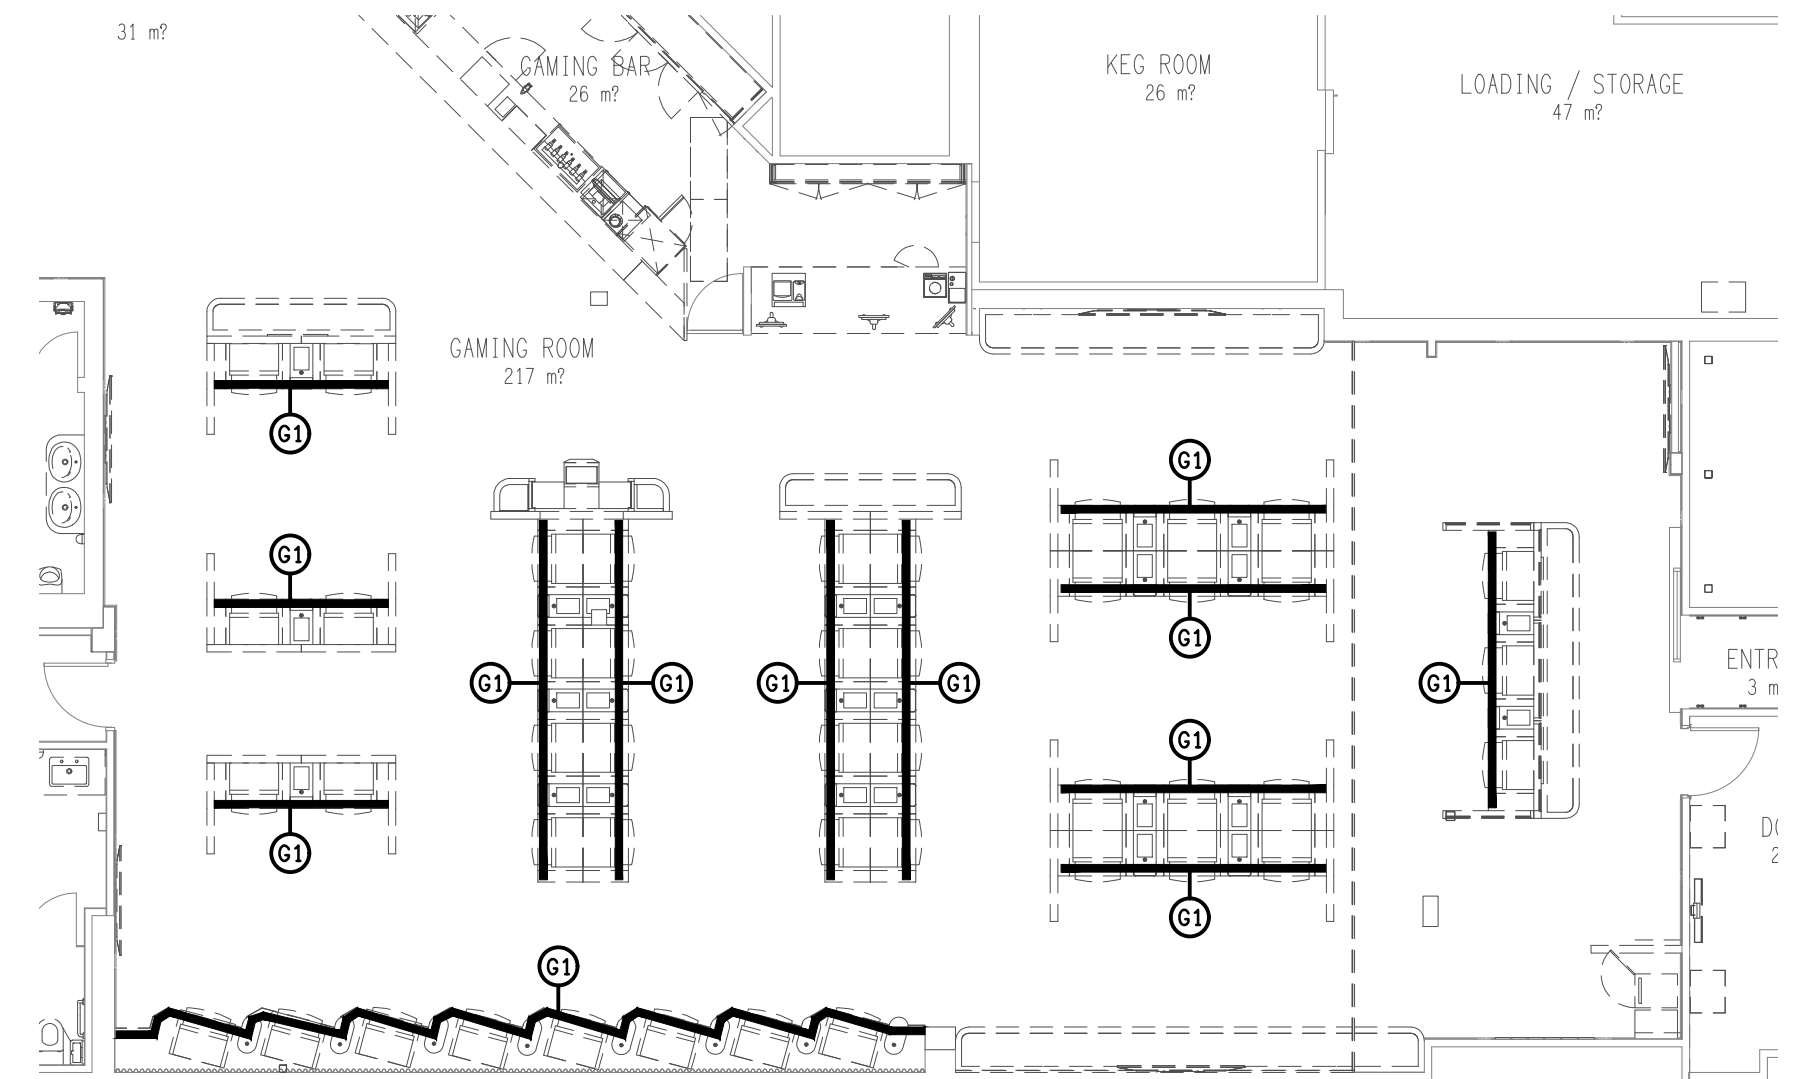


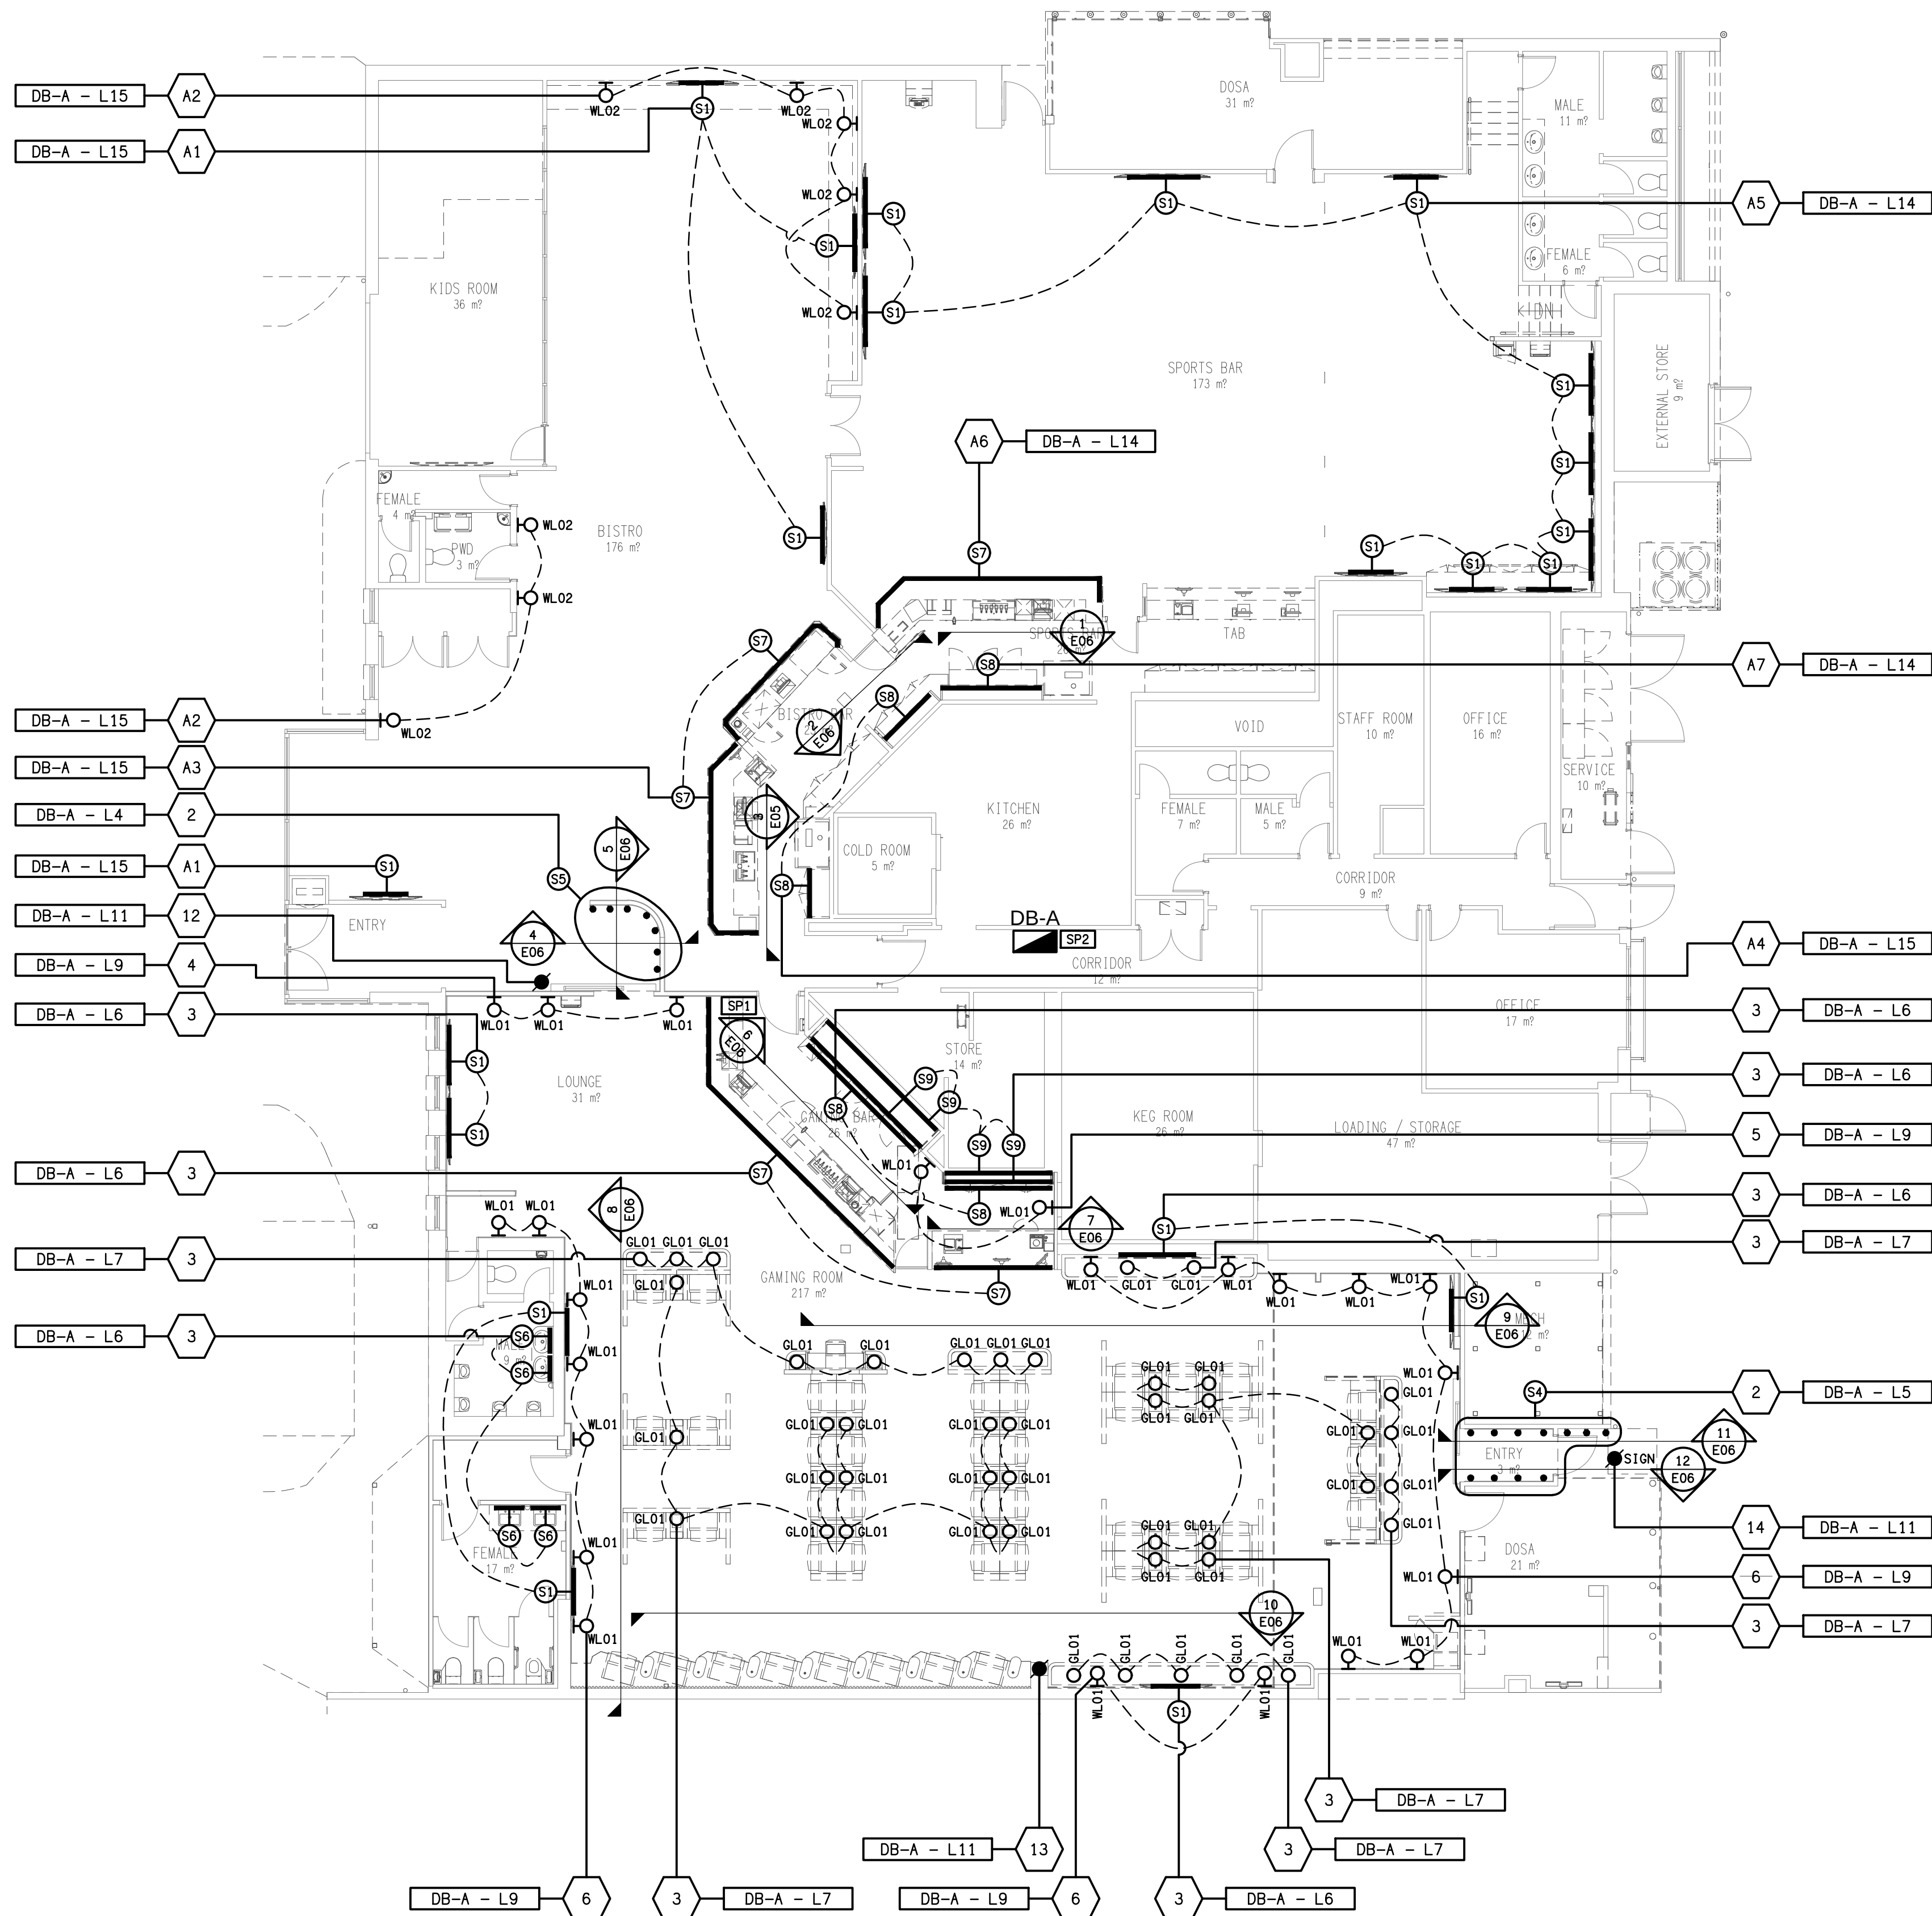

NOTE:
(G1) GAMING MACHINE BASE LEDS
BY THE GAMING ELECTRICIAN.

GAMING ROOM
G1 GAMING MACHINE BASE STRIP LIGHTING
SCALE 1:100

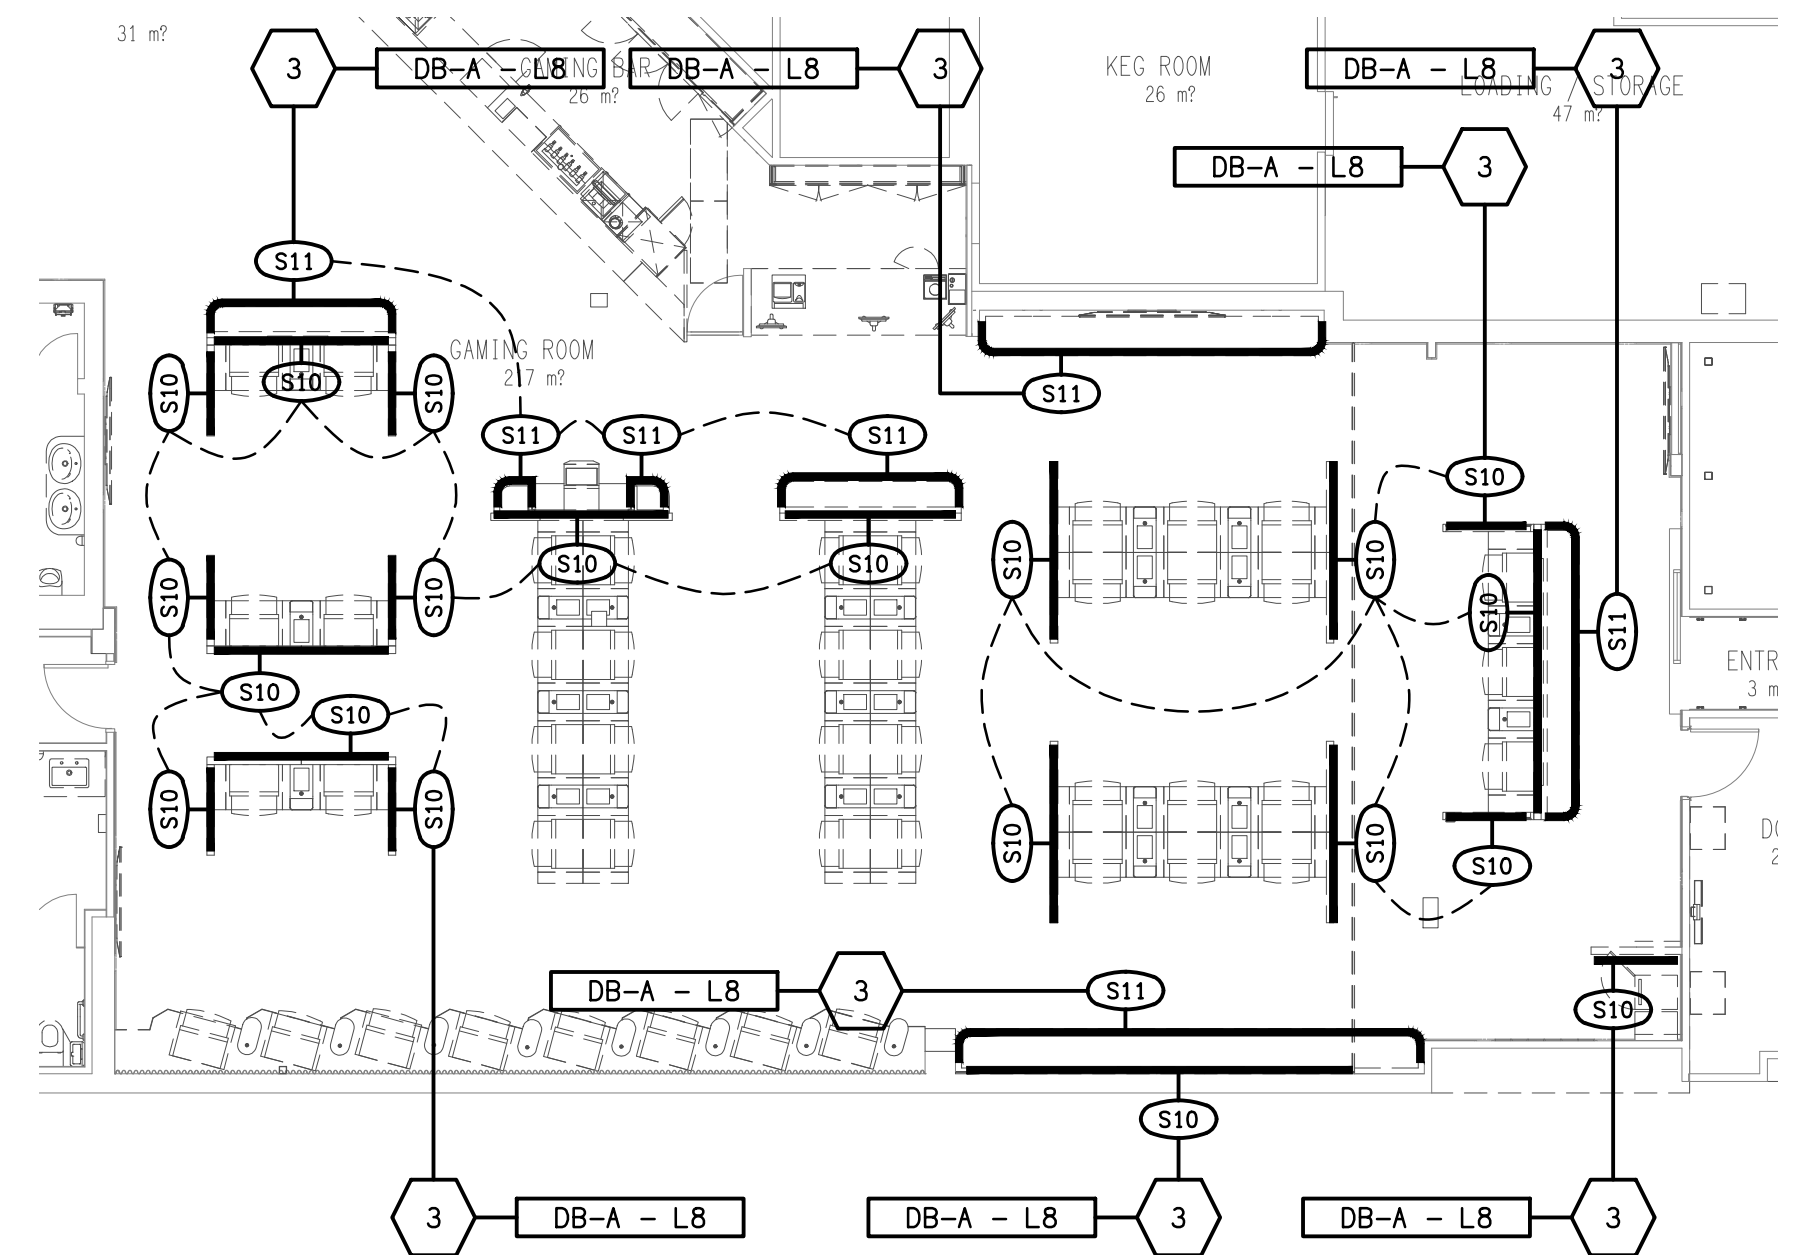

GAMING ROOM
S10 SCREEN & S11 PLANTER LIGHTING
SCALE 1:100

ELECTRICAL DESIGN GROUP BRISBANE
PTY LTD
ACN 092 710 793
TRADING AS:
ELECTRICAL DESIGN GROUP

THE COPYRIGHT OF THIS DRAWING
REMAINS THE PROPERTY OF THE
ELECTRICAL DESIGN GROUP.
USE FIGURED DIMENSIONS
IN PREFERENCE TO SCALE.
ALL DIMENSIONS TO BE
VERIFIED ONSITE.

ELECTRICAL DESIGN GROUP
ELECTRICAL BUILDING SERVICES CONSULTANTS
BRISBANE GOLD COAST

P.O.Box 15, Sherwood Qld 4075
Phone: 0418 893 338
Email: brisbane@edg.net.au
Web: www.edg.net.au

PROJECT:
CAPTAIN COOK TAVERN, KIPPA RING

PENINSULA FAIR SHOPPING CENTRE, ANZAC AVE, KIPPA RING

B	TENDER	18/09/2026
REV.	DESCRIPTION:	DATE:

DRAWING:
ELECTRICAL SERVICES
JOINERY & WALL LIGHTING PLANS

SCALE: 1:100	AT A1	PROJECT NO: C3813a	DRAWING NO: E05	REVISION: B
-----------------	-------	------------------------------	---------------------------	-----------------------