



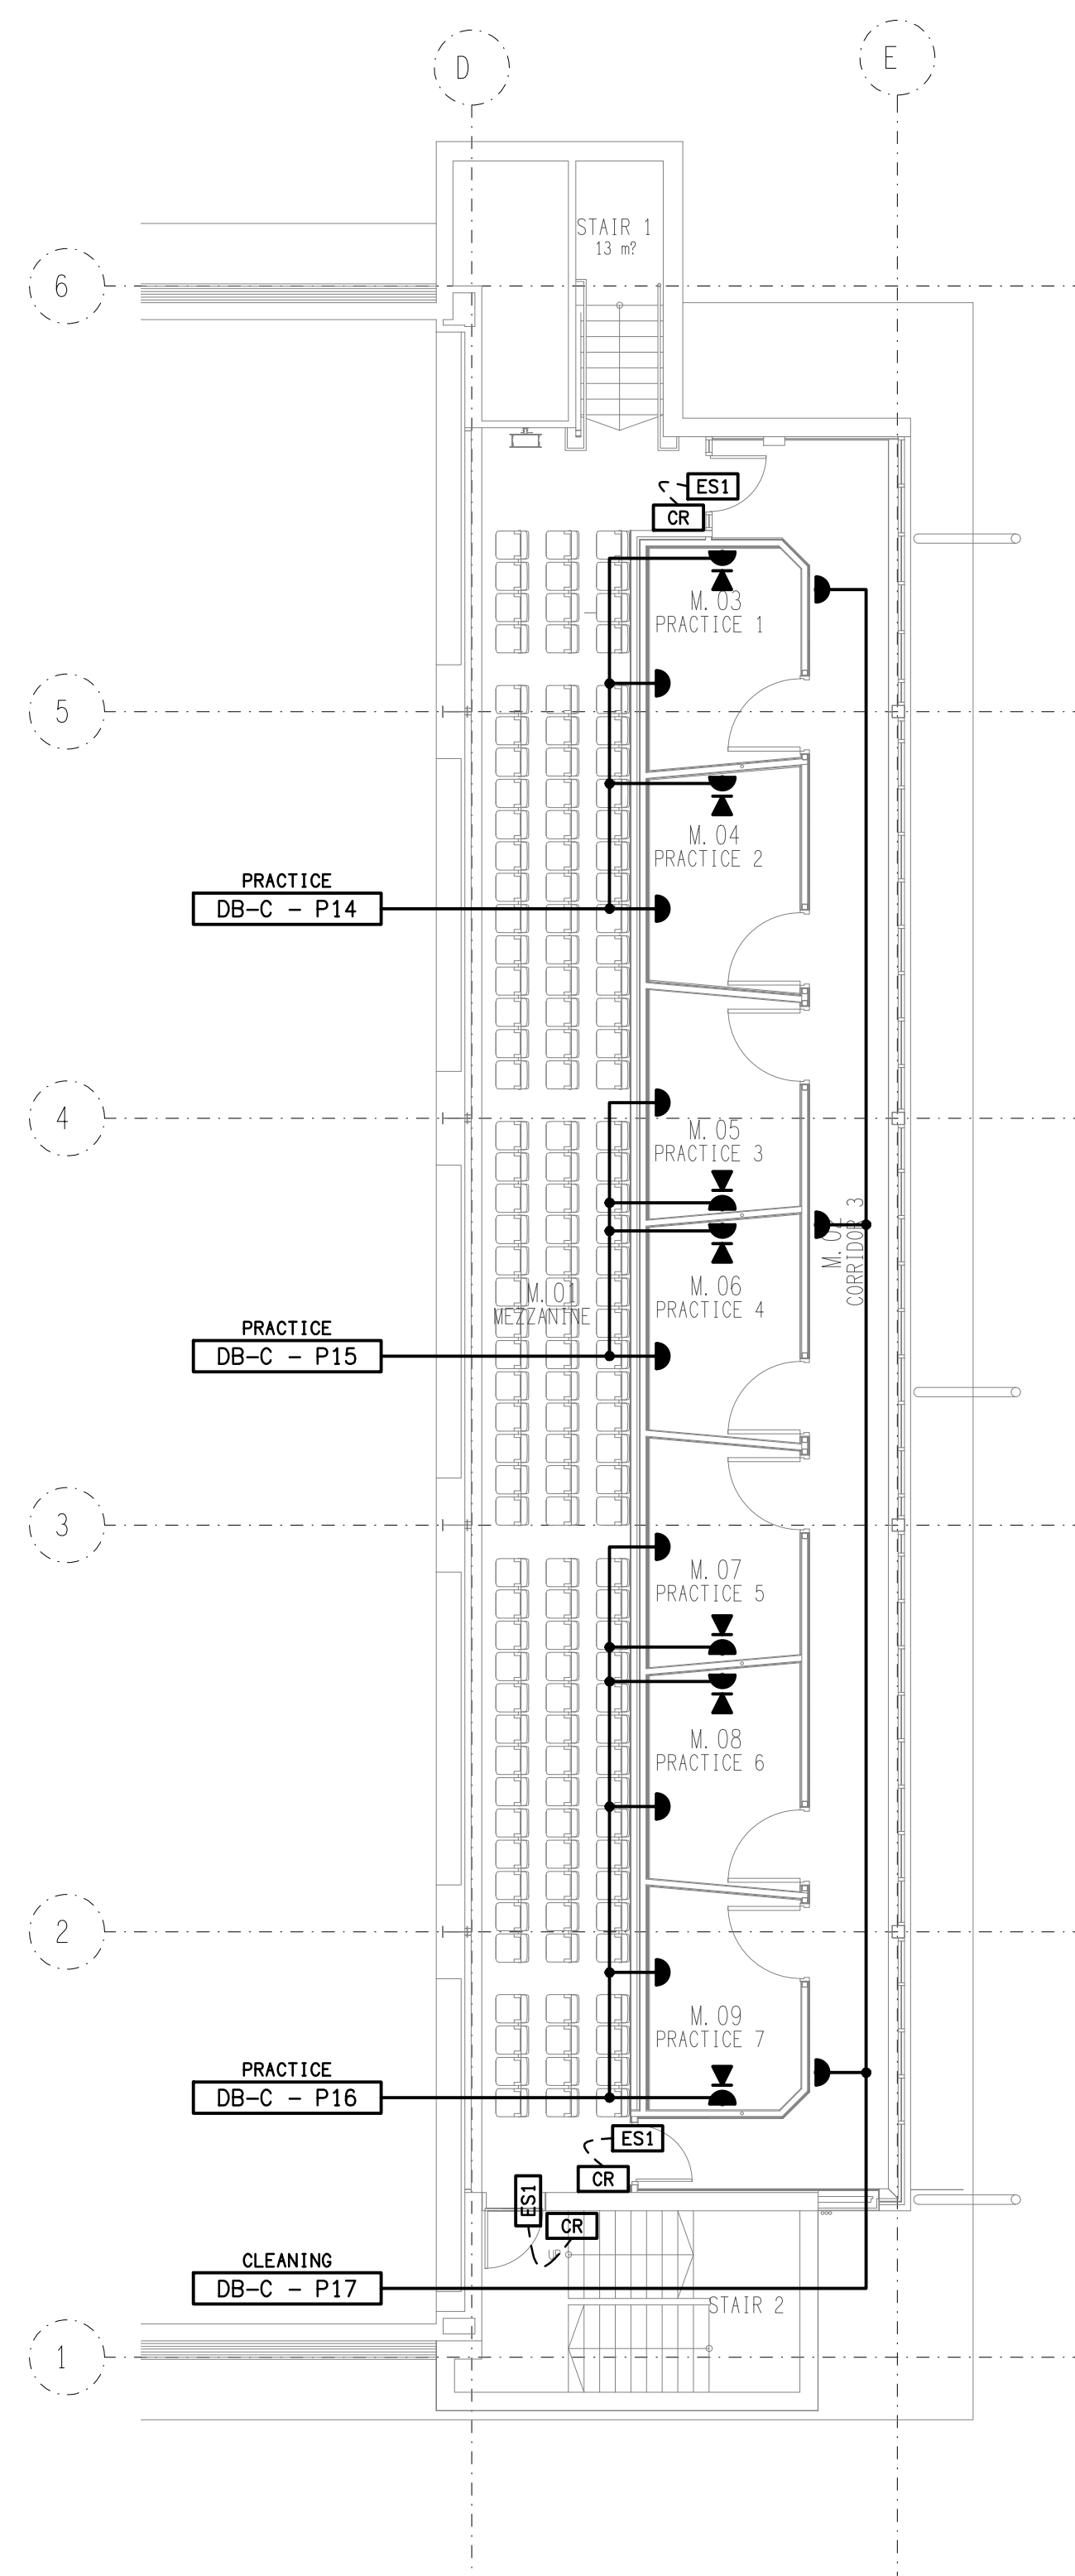

FLOOR PLAN
CAMPBELL CENTRE REFURBISHMENT
SCALE 1:100

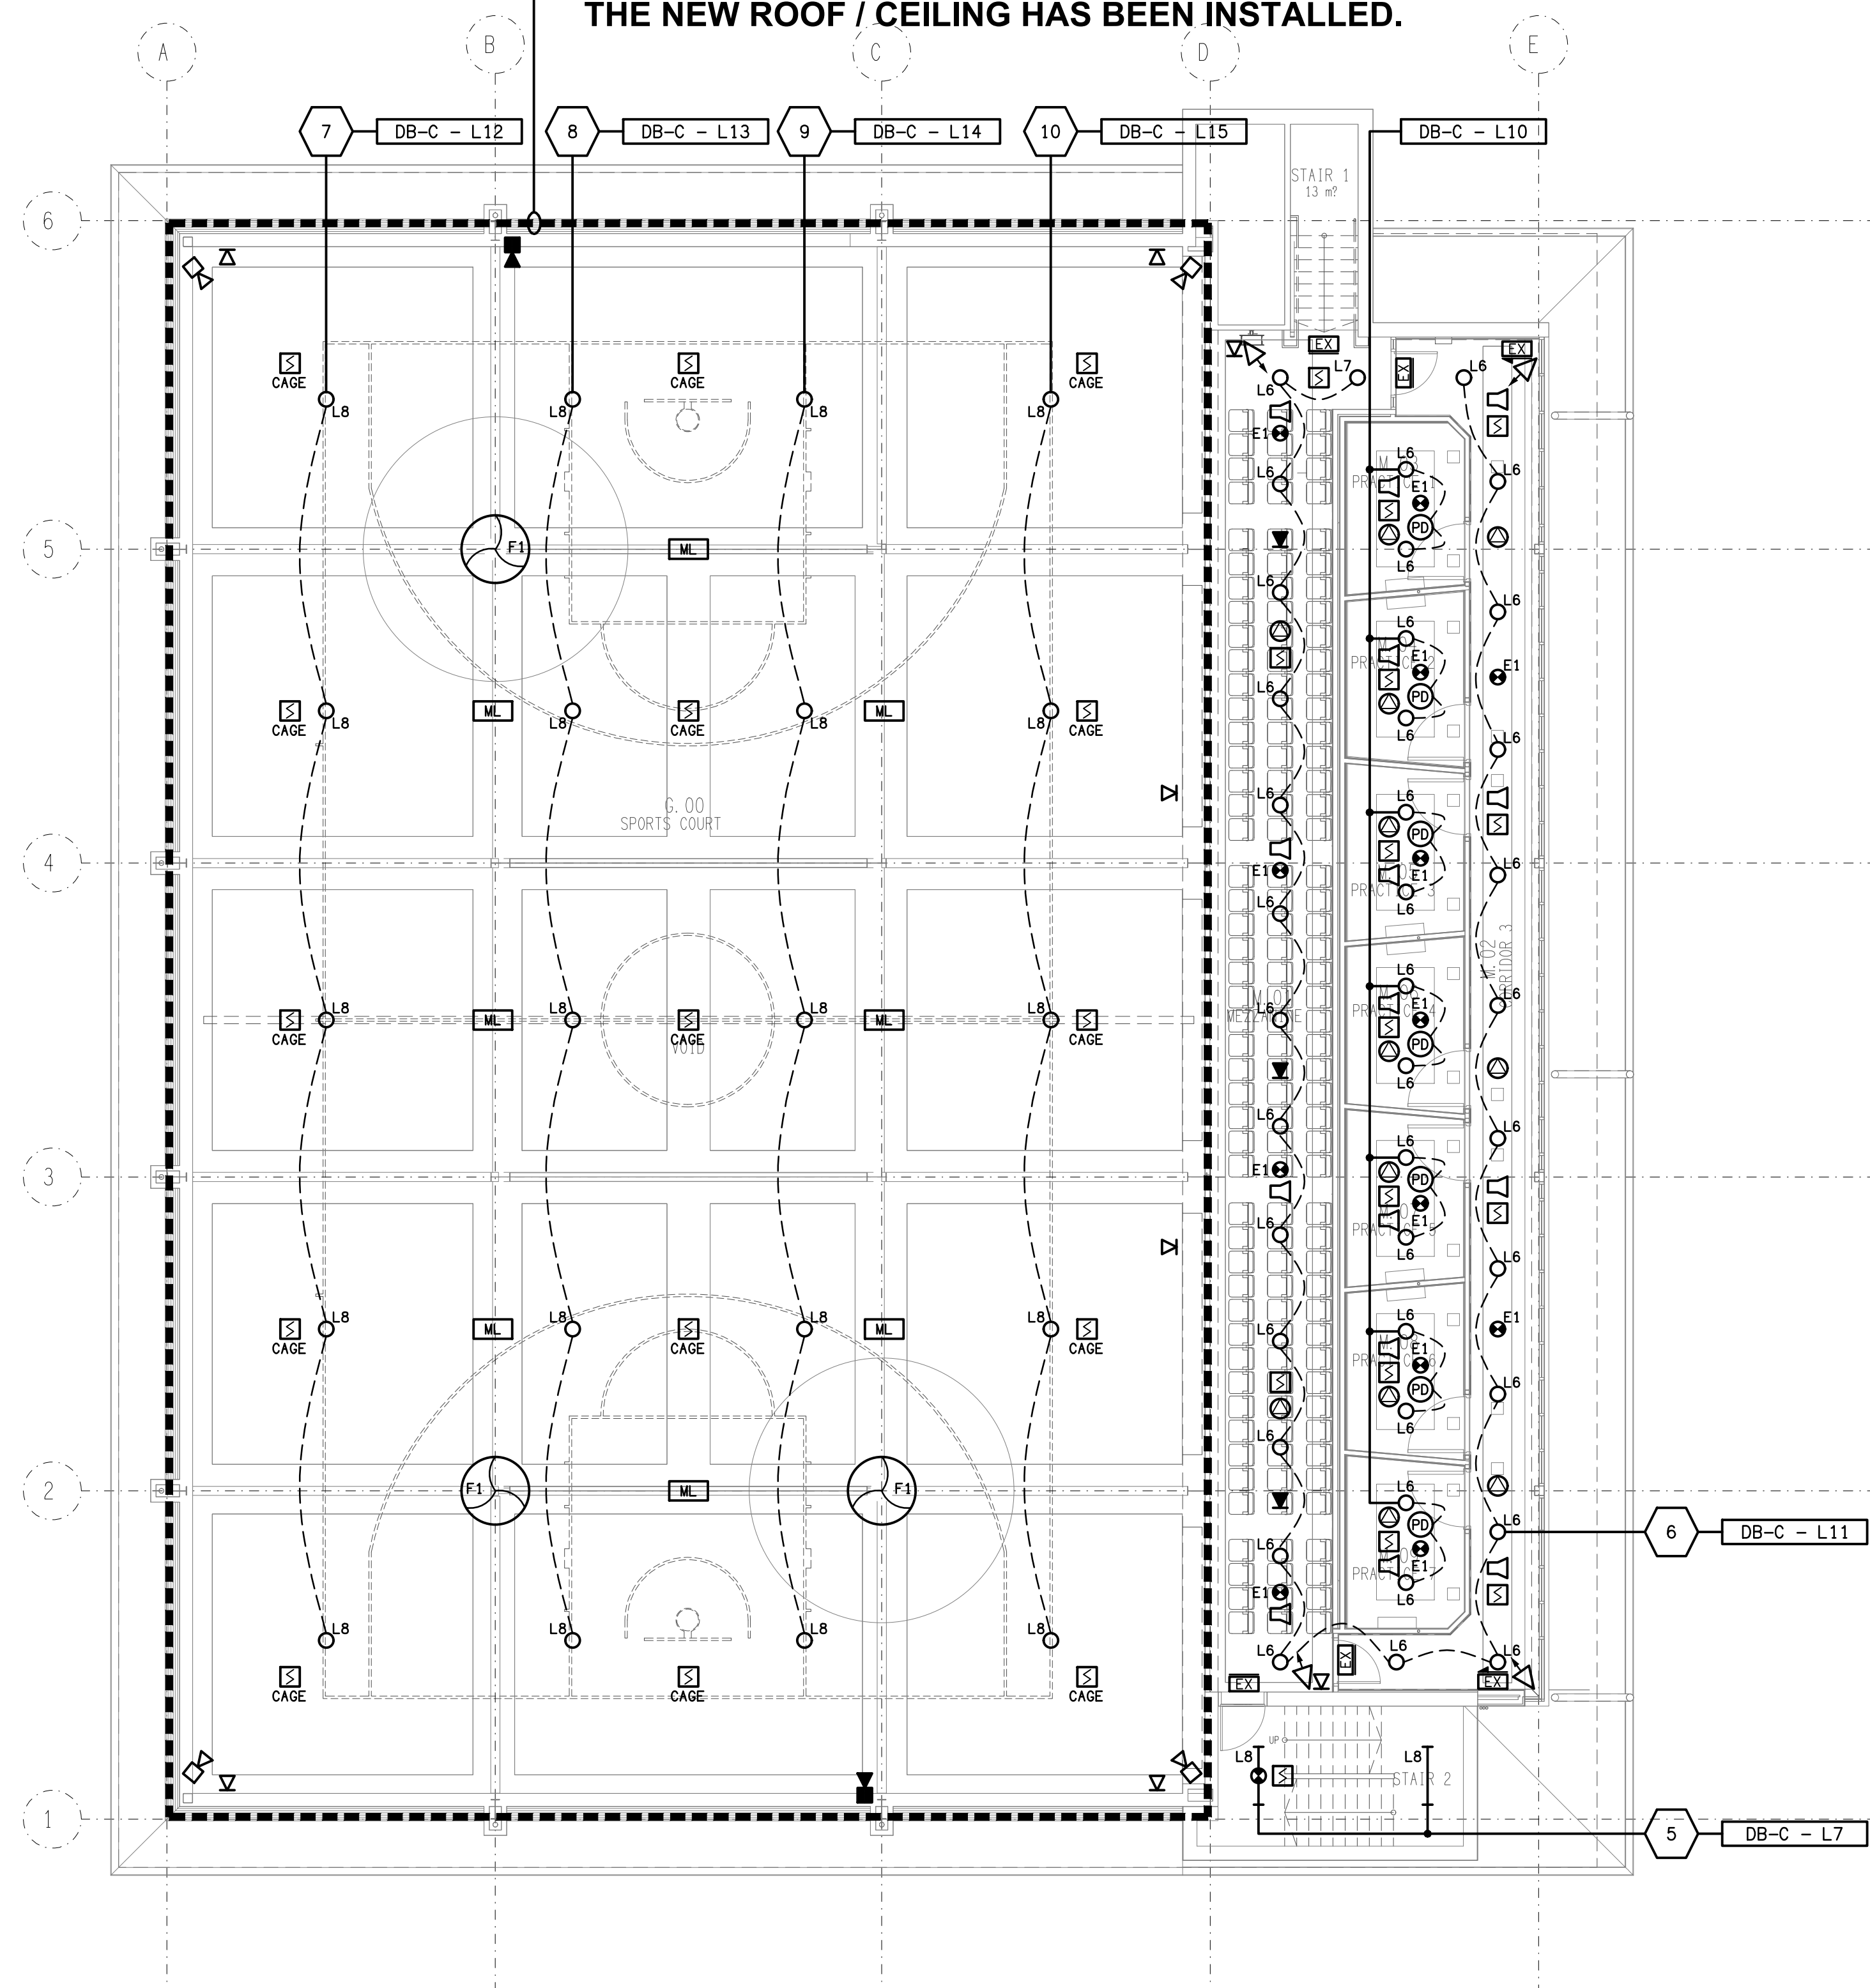

REFLECTED CEILING PLAN
CAMPBELL CENTRE REFURBISHMENT
SCALE 1:100

REMOVE THE EXISTING SCHOOL BELL, FIRE ALARM SPEAKERS AND FIRE DETECTORS WITHIN THIS DASH LINED AREA. PROVIDE NEW SPEAKERS AND DETECTORS AS INDICATED. REINSTATE THE EXISTING FANS, L8 LIGHTS AND MOTORISED LOUVRES ONCE THE NEW ROOF / CEILING HAS BEEN INSTALLED.

ELECTRICAL DESIGN GROUP BRISBANE
PTY LTD
ACN 092 710 793
TRADING AS:
ELECTRICAL DESIGN GROUP

THE COPYRIGHT OF THIS DRAWING
REMAINS THE PROPERTY OF THE
ELECTRICAL DESIGN GROUP.
USE FIGURED DIMENSIONS
IN PREFERENCE TO SCALE.
ALL DIMENSIONS TO BE
VERIFIED ONSITE.

ELECTRICAL DESIGN GROUP
ELECTRICAL BUILDING SERVICES CONSULTANTS
BRISBANE GOLD COAST

P.O.Box 15, Sherwood Q.4075
Phone: 0418 893 338
Email: brisbane@edg.net.au
Web: www.edg.net.au

PROJECT:
ANGLICAN CHURCH GRAMMAR SCHOOL
CAMPBELL CENTRE REFURBISHMENT

OAKLANDS PARADE, EAST BRISBANE

T1	TENDER	06/10/2026
REV:	DESCRIPTION:	DATE:

DRAWING:
ELECTRICAL SERVICES
MEZZANINE LEVEL PLANS

SCALE: 1:100	AT A1	PROJECT NO: C3857a	DRAWING NO: E06	REVISION: T1
-----------------	-------	------------------------------	---------------------------	------------------------